


1. ELECTRICAL INSTALLATION MUST BE COMPLETED BY A QUALIFIED ELECTRICIAN IN ACCORDANCE WITH ALL APPLICABLE CODES AND REGULATIONS
2. CONFIRM THAT THE MAINS VOLTAGE CONFORMS TO REQUIREMENTS BEFORE CONNECTING THE MACHINE OR ACCESSORIES
3.  NOMINAL VOLTAGE. VOLTAGES AS LOW AS 208V ARE PERMISSIBLE BUT WILL REDUCE SPINDLE PERFORMANCE.

ITEM NO.	DEVICE	VOLTAGE	RUNNING WATTAGE	PEAK WATTAGE	BREAKER	CONNECTOR
1	BASE MACHINE • LATHE • CONTROLLER • LIGHTING • COOLANT	240V (1Ø) 	5.4kW	12.0kW	30A	NEMA L6-30P
2	OIL SKIMMER (OPTION)	120V (1Ø)	0.2kW	0.2kW	15A	NEMA 5-15P

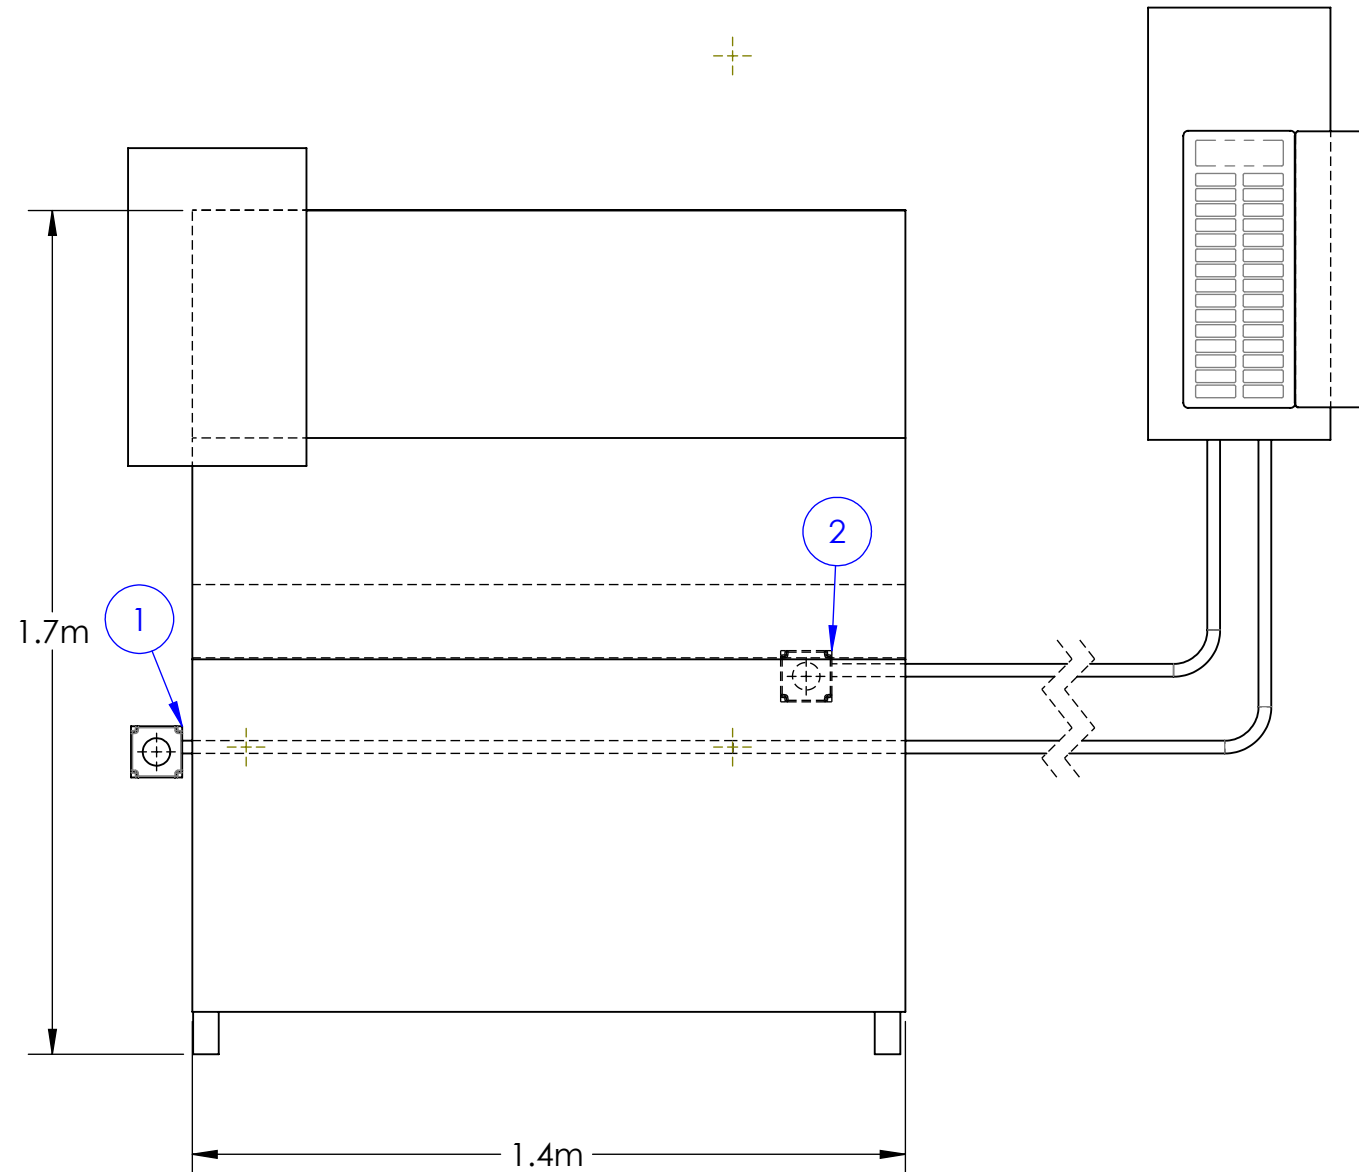

 TORMACH® 4009 FELLAND ROAD, STE. 120 MADISON, WI 53716 (608) 849-8381			DRAWN BY		DATE		TITLE: ELECTRICAL SITE PLAN, 15LX						
			PDDH		2025-09-23								
	ALL UNITS IN METERS								SIZE B		DWG. NO.		REV A+
DO NOT SCALE DRAWING						SCALE: 1:15				SHEET 1 OF 1			

A	INITIAL RELEASE	2024-03
REV.	DESCRIPTION	DATE
REVISIONS		